## CONSTRUCTION DRAWINGS

## RELOCALIZACIÓN DE COMPACTADORA DE BASURA

WORLD PLAZA

AVENIDA LUIS MUÑOZ RIVERA

SAN JUAN, PR


## DRAWING INDEX

1 T-1 TITLE SHEET
2 D-01 DEMOLITION PLAN
3 B-01 BASIS OF DESIGN
4 SI-1 SITE IMPROVEMENTS PLAN
5 SI-2 SITE IMPROVEMENTS DETAILS
6 SI-3 FENCE ELEVATION AND DETAILS
7 SI-4 GENERAL NOTES


7 SI-4 GENERAL NOTES

8 P-1 PLIMBING PLAN AND NOT

8 P-1 PLUMBING PLAN AND NOTES 9 E-1 ELECTRICAL PLAN AND NOTES

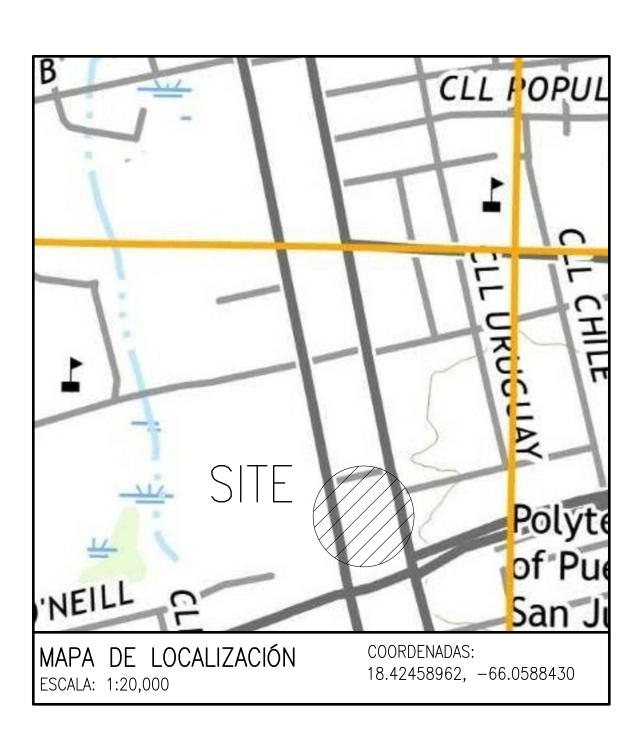



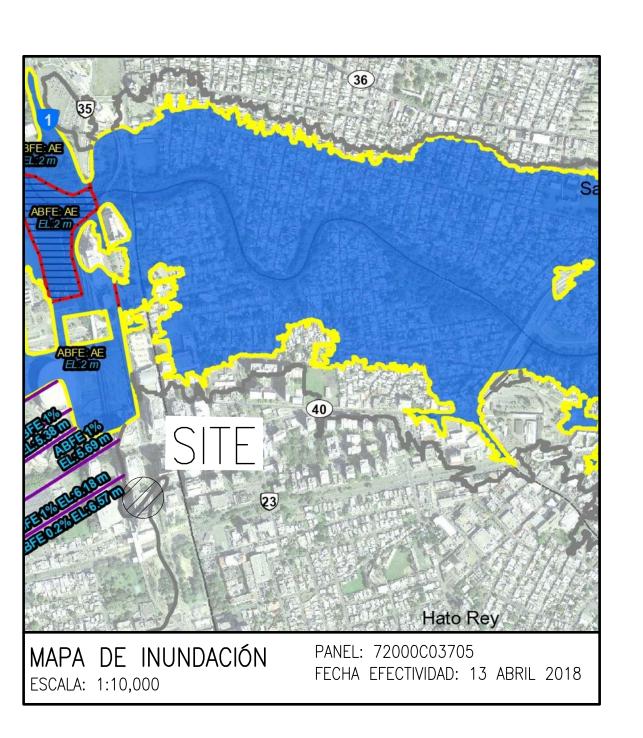

MANUEL GARCIA ANGELI

M E C H A N I C A L E N G I N E E R I N G

THE HATO REY CENTER SUITE 405 268 PONCE DE LEON AVE. HATO REY

MGARCIA.PE@GMAIL.COM

PO BOX 270421 SAN JUAN, PR 00928 787 373 9460

THIS DRAWING OR PRINT DEPICTS
THE DESIGN EFFORT OF MGA
CONSULTING ENGINEER, AND IS
ISSUED FOR REVIEW SOLELY AS
AN INSTRUMENT OF THE SERVICES
BEING RENDERED. IT REMAINS THE
PROPERTY OF THIS OFFICE,
SHALL BE USED ONLY BY
AUTHORIZED PERSONS, AND
SHALL NOT BE COPIED,
REPRODUCED OR EXHIBITED
UNLESS PERMISSION IN WRITING IS
GRANTED. IT SHALL BE RETURNED
UPON REQUEST.

PROFESSIONAL SEAL:

PROJECT

WORLD PLAZA -RELOCALIZACIÓN COMPACTADORA DE BASURA

SAN JUAN

Puerto Rico

REVISIONS		
Rev	Date	Description
0	01 MAR 23	NEW DRAWING
1	15 FEB 24	GENERAL REVISION
File N	ame: .	
Scale: AS SHOWN		N Date: FEB 2023

TITLE SHEET

DRAWING TITLE

T-1